

KEY

SURROUNDING FACILITIES:

- * RESTAURANT
- BANKING FACILITY.
- O CONVENIENCE FACILITY
- **EMERGENCY ROOM**
- PUBLIC TRANSPORTATION: BUS

//// PARKING FACILITIES

NOTES


NEIGHBORHOOD:

69TH STREET IS A COMMERCIAL AREA WITH SMALL BUSINESSES. THE OUTSKIRTS ARE MOSTLY RESIDENTIAL. STREETS ARE MOSTLY CLEAR WITH FLUID CIRCULATION.

BUILDING CONTEXT & HISTORY:

- . LOCATION : MIDTOWN SAVANNAH
- . DATE BUILT: 1987
- · COMMUNITY CULTURE: AFRICAN AMERICAN, CAUCASIAN

LEDGENS AND SYMBOLS

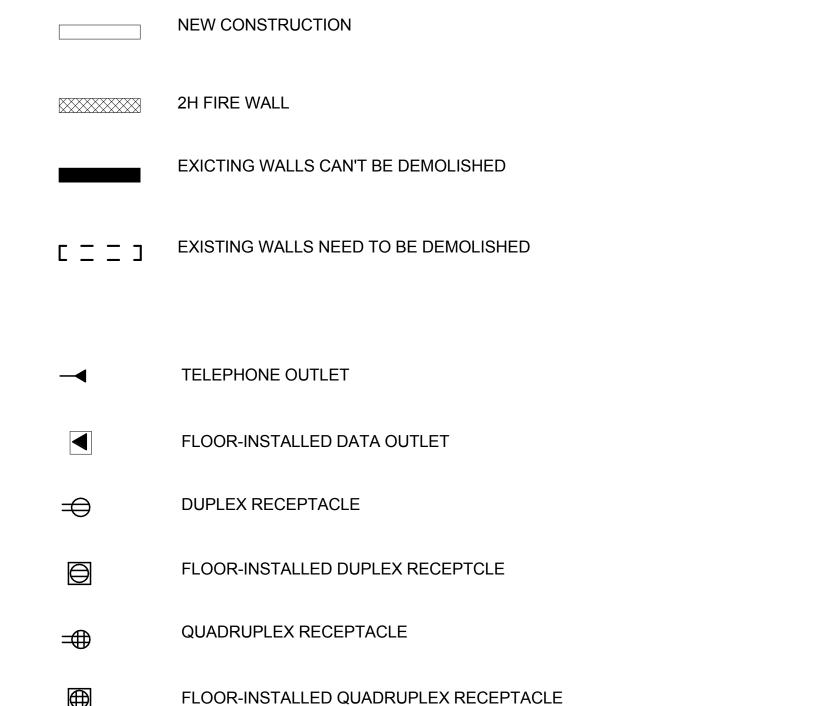

FIRE ALARM SPEAKER/STROBE

FIRE EXTINGUISHER CABINET

O RECESSED DOWNLIGHT

FIRE HOSE CABINET

EXIT LIGHTS

TRAVEL PATH

PENDENT / CHANDELIER

A' FLUORESCENT STRIP FIXTURE

EXIT LIGHTS

EXIT LIGHTS

QUARDRUPLEX RECEPTACLE GROUND FAULT INTERRUPT

240V APPLIANCE RECEPTACLE


WALL POCKET OUTLET BOX

SUPPLY

RETURN

* SPRINKLER

AUTO LIGHTING SHADE

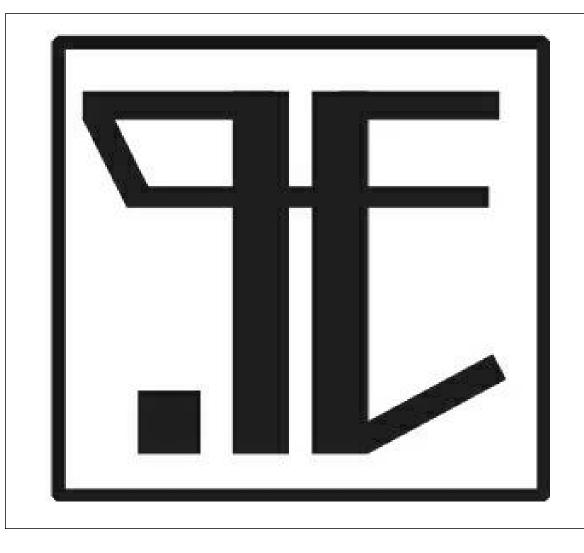

COJOLYA ASSOCIATION OF MAYA WOMEN WEAVERS

COVER PAGE

Drawn By


Checked By

MARCH 3RD, 2013 ENYA YUN HUANG ESMA DENGIZ

A 101

Scale

2/22/2018 11:53:07 PM

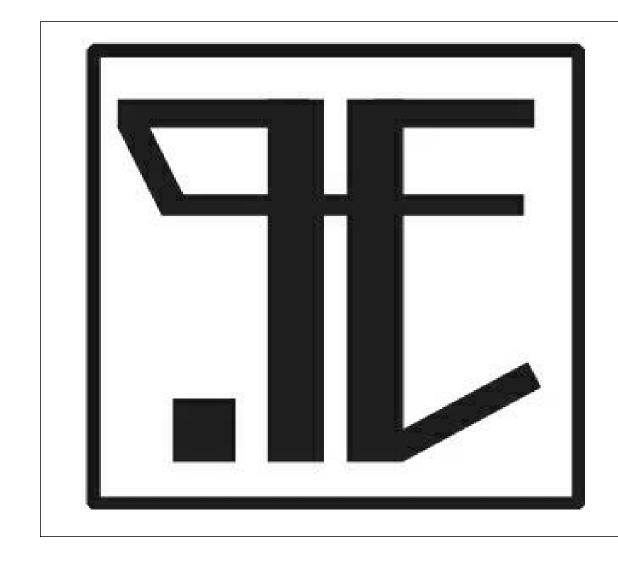

SECOND FLOOR DEMOLITION PLAN

Date
Drawn By
Checked By

MARCH 3RD, 2013 ENYA YUN HUANG ESMA DENGIZ

A 102

Scale



SECOND FLOOR DEMOLITION PLAN



SECOND FLOOR LIFE SAFETY PLAN

Drawn By
Checked By

TRAVEL PATH

MARCH 3RD, 2013 ENYA YUN HUANG ESMA DENGIZ

A 103

ale

SECOND FLOOR LIFE SAFETY PLAN

SCALE 1/8" = 1'-0"

OCCUPANCY CLASSIFICATION: 60
FLOOR AREA: GROSS: 7070 NET 6950
HEIGHT: 10'8"
BUILDING TYPE: OFFICE
BUILDING CONSTRUCTION TYPE: PRE-ENGINEERED



OLYA ASSOCIATION MEAN WEAVERS

SECOND FLOOR PLAN

Drawn By
Checked By

MARCH 3RD, 2013 ENYA YUN HUANG ESMA DENGIZ

A 104

Scale

SECOND FLOOR PLAN




SECTION

Date
Drawn By
Checked By


MARCH 3RD, 2013 ENYA YUN HUANG ESMA DENGIZ

A 105


Scale

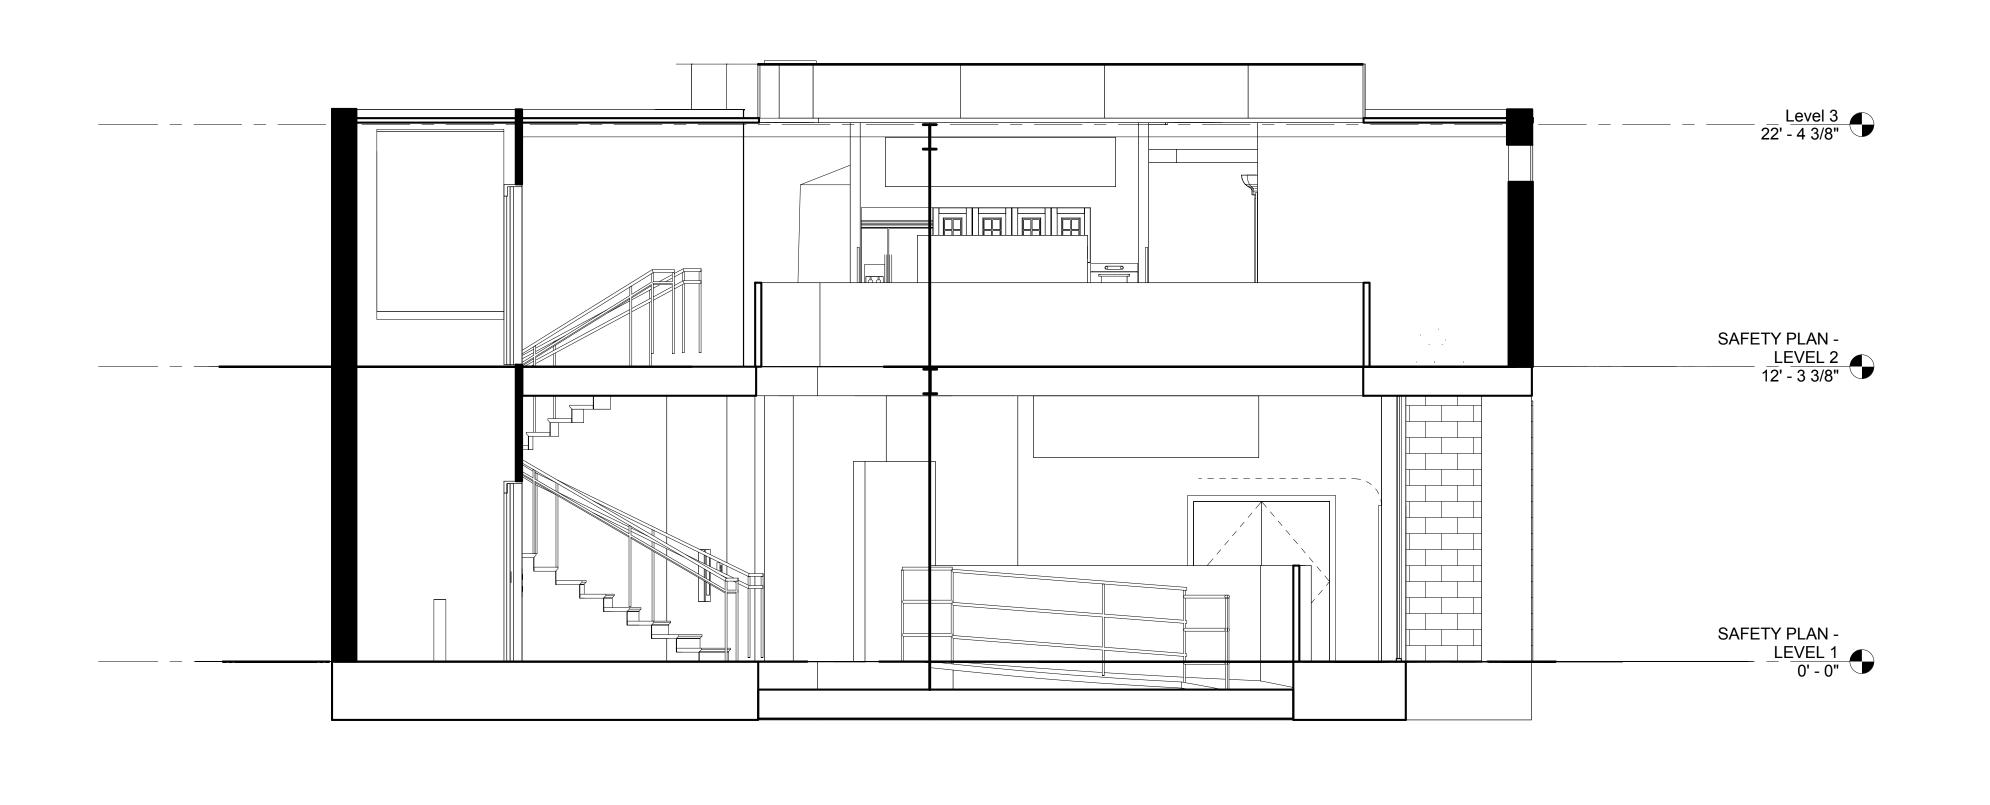

TRANSVERSE SECTION
1/4" = 1'-0"

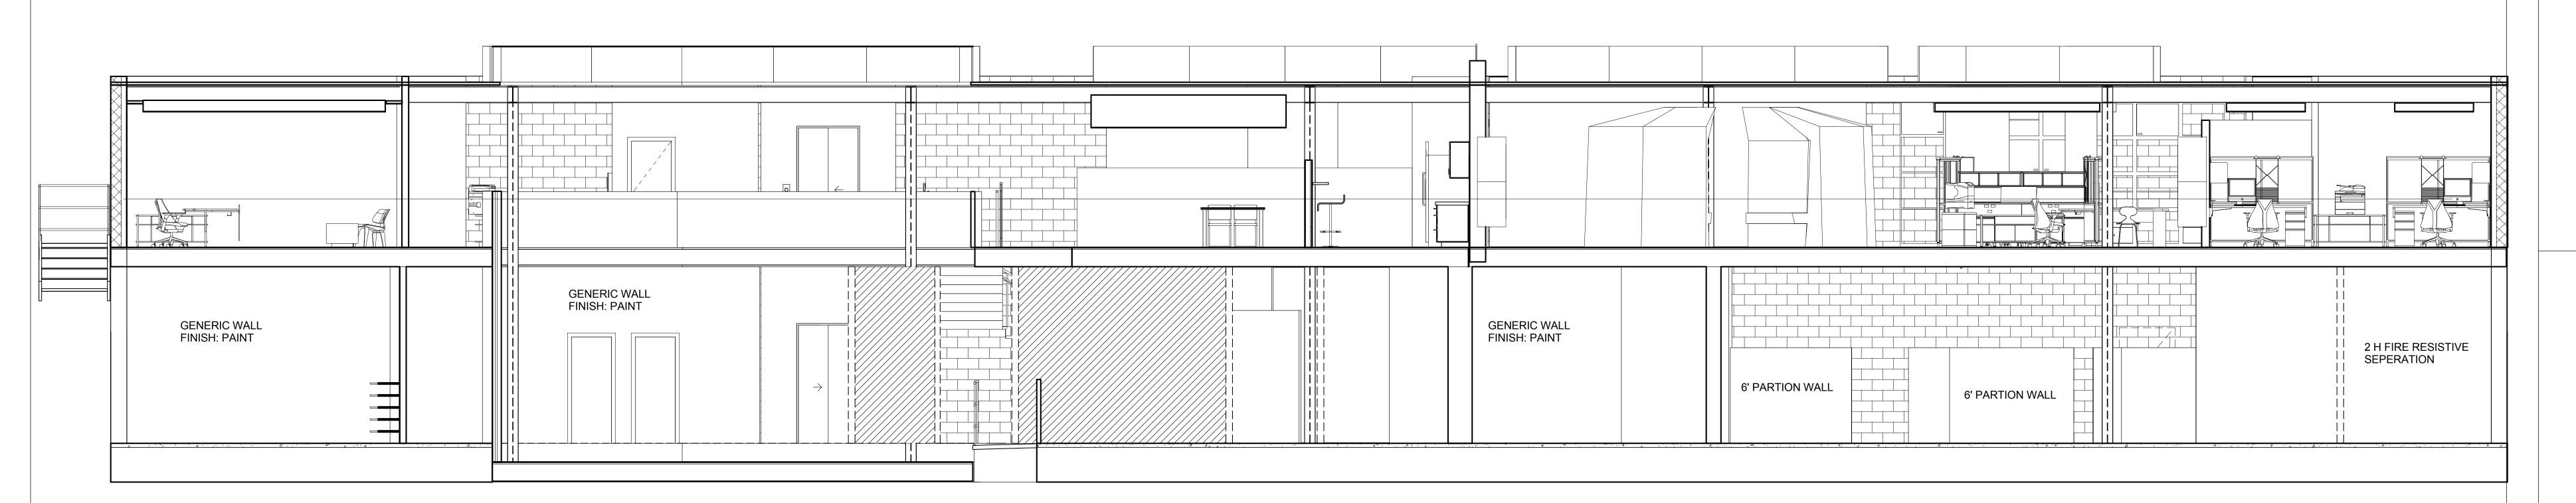

LONGITUDUNAL SECTION

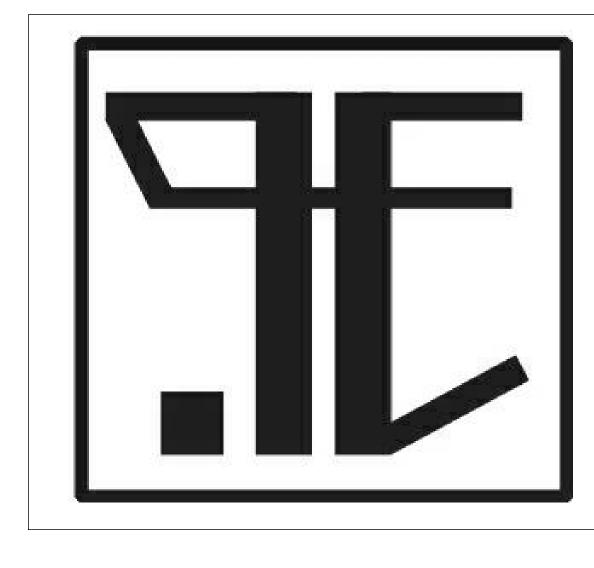


SECOND FLOOR POWER / DATA / COMMUNICATION PLAN


Date
Drawn By
Checked By

MARCH 3RD, 2013 ENYA YUN HUANG ESMA DENGIZ

E 101


Scale

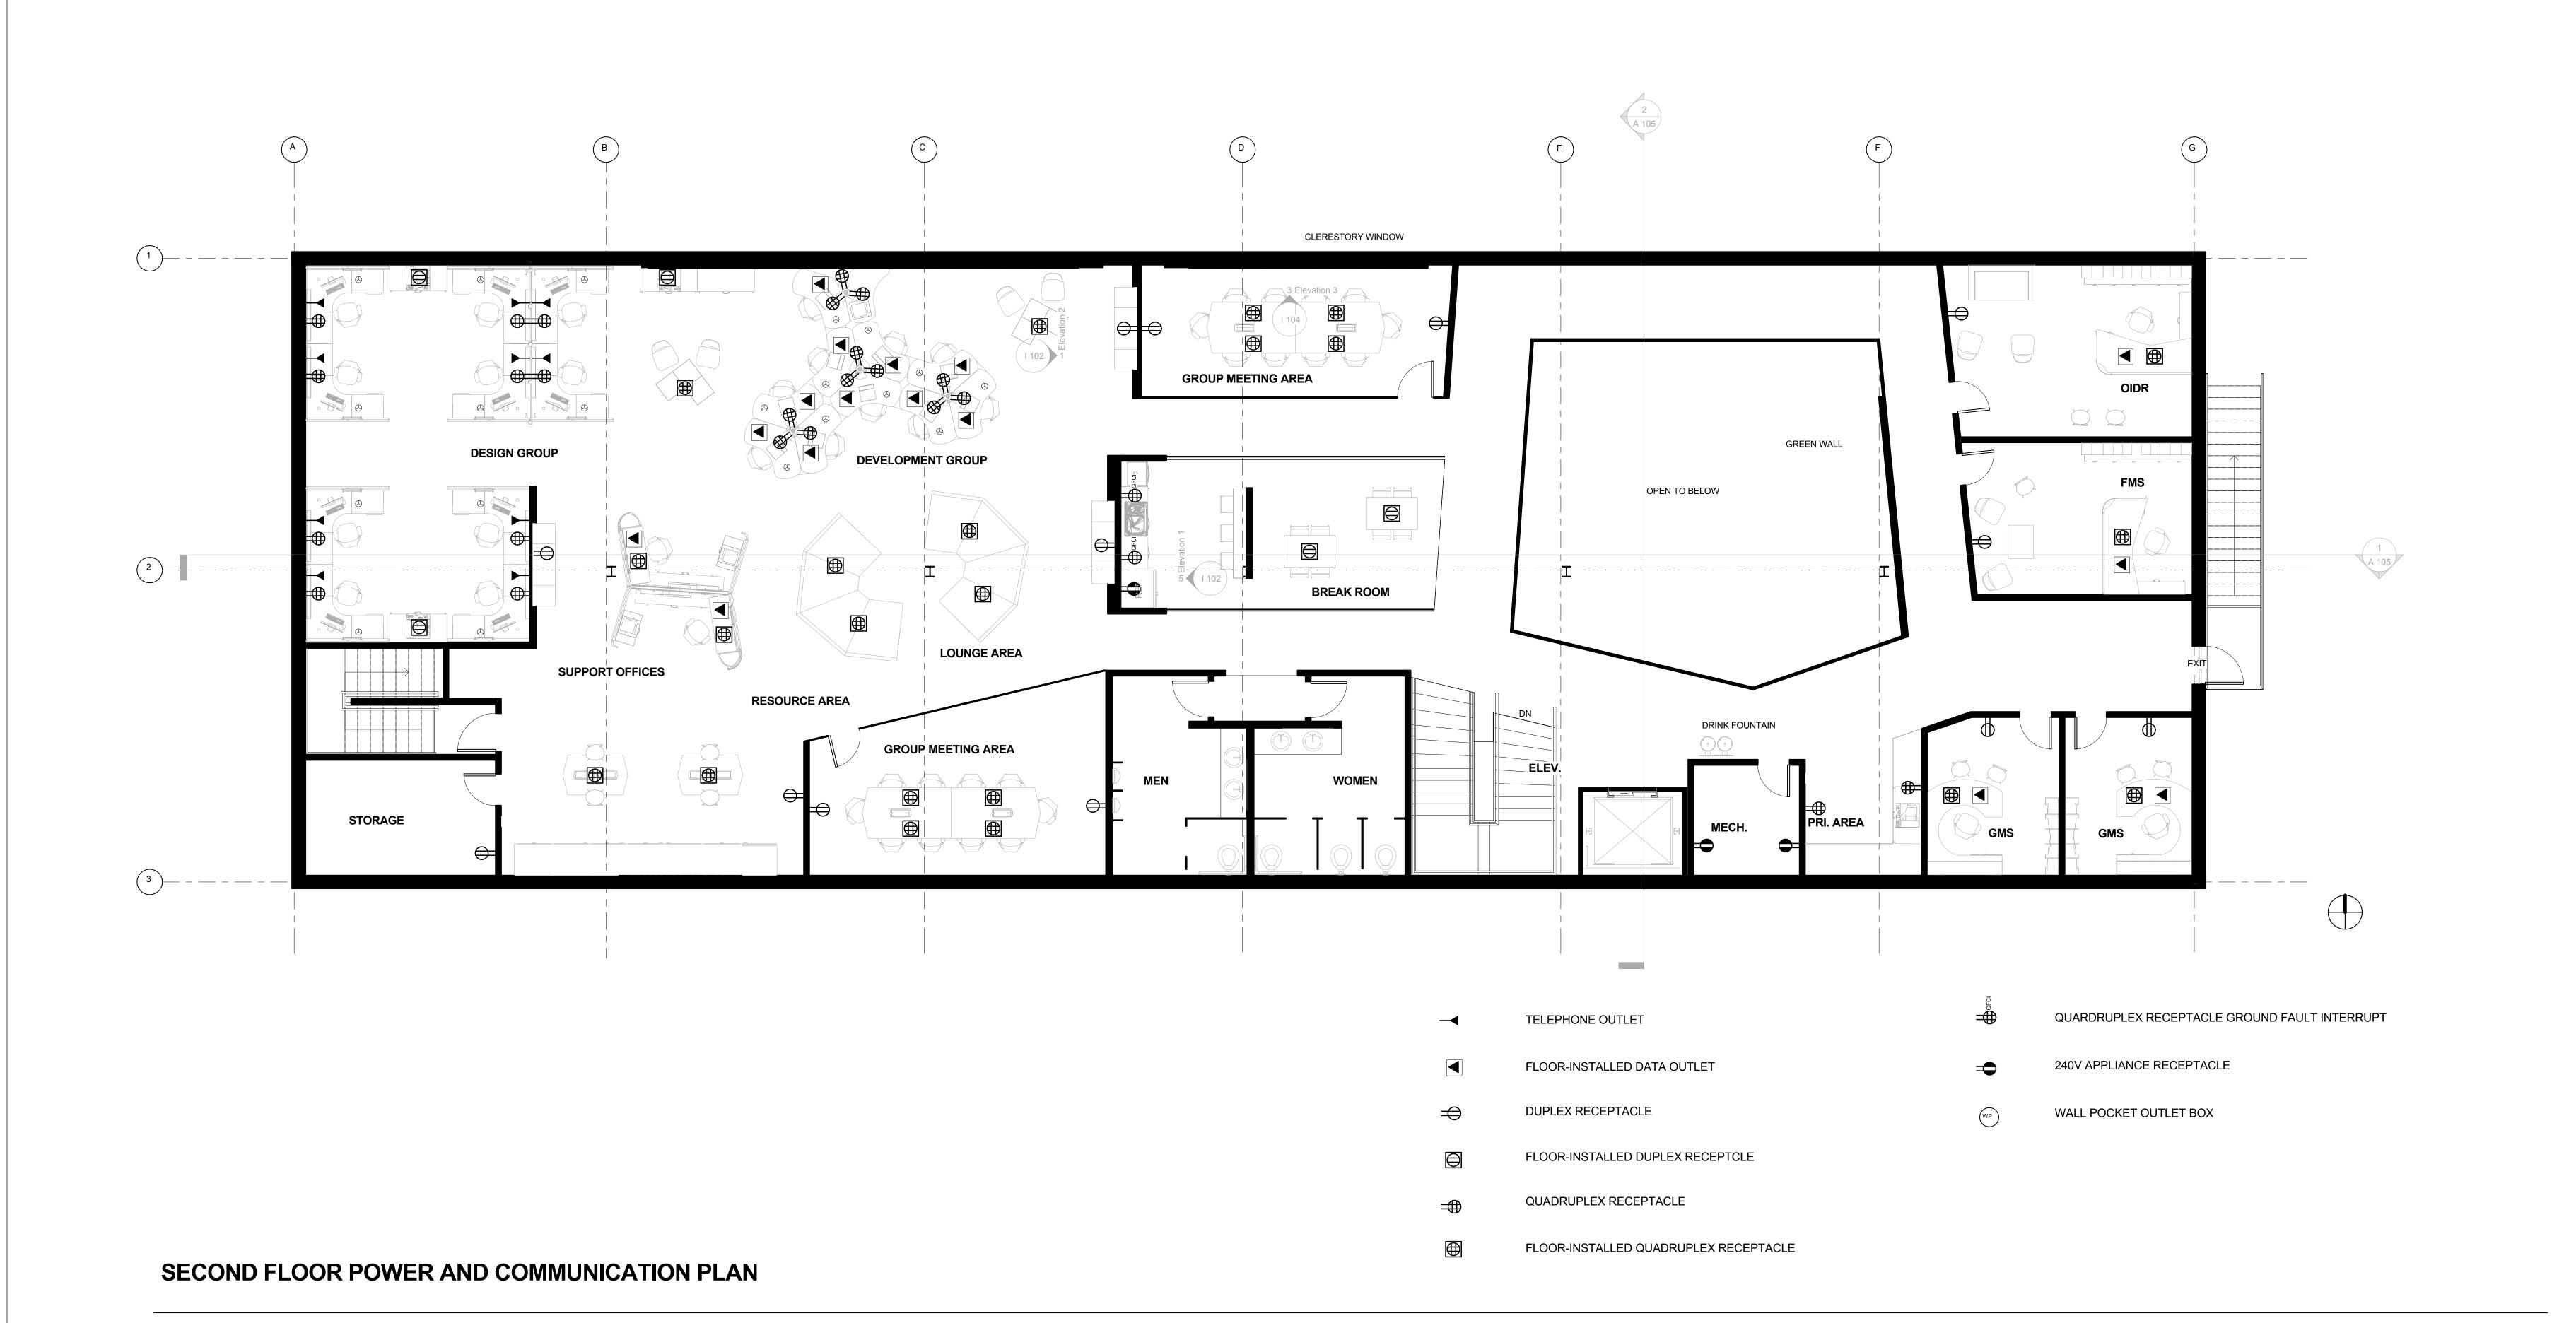

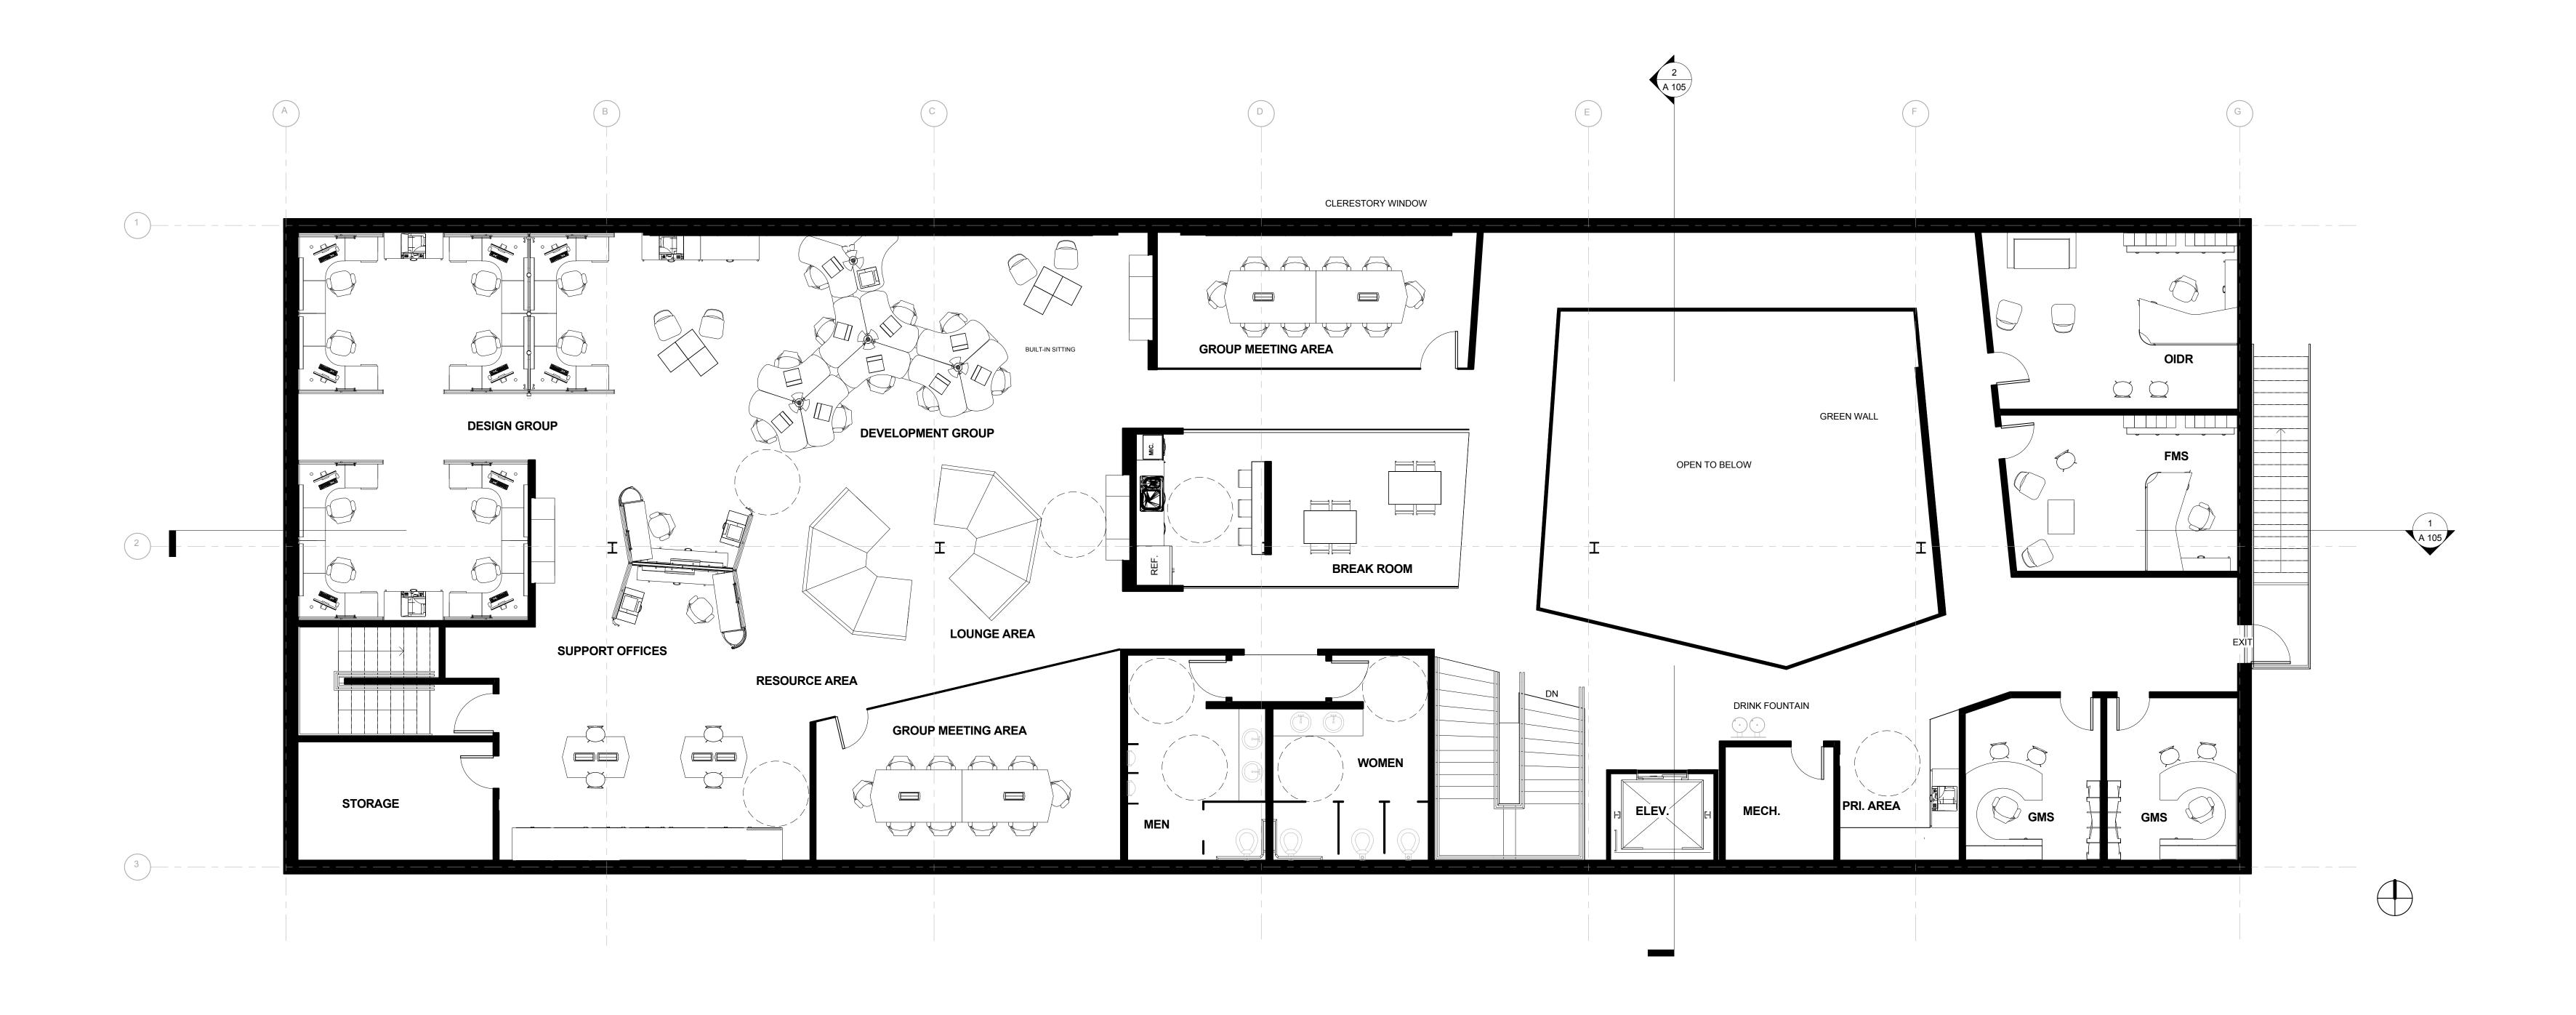

SECOND FLOOR FURNITURE LAYOUT PLAN

SCALE 1/8" = 1'-0"

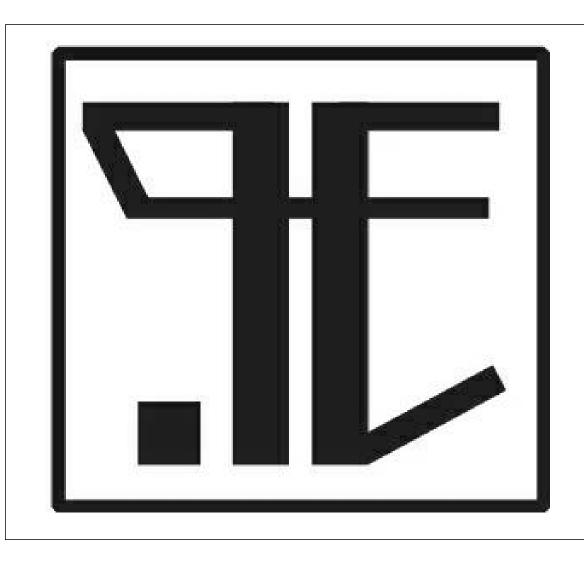

SOJOLYA ASSOCIATION OF MAYA WOMEN WEAVERS

SECOND FLOOR FURNITURE LAYOUT PLAN


Drawn By
Checked By

MARCH 3RD, 2013 ENYA YUN HUANG ESMA DENGIZ

I 101


rale

00/00/00 40/00/00

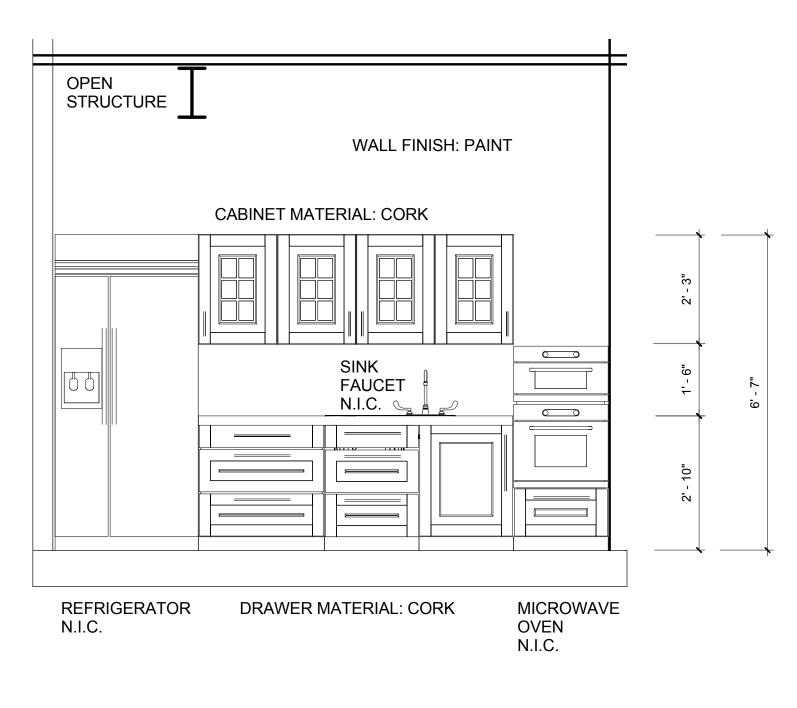


SECOND FLOOR ELEVATION 1

SCALE 1/2" = 1'-0"

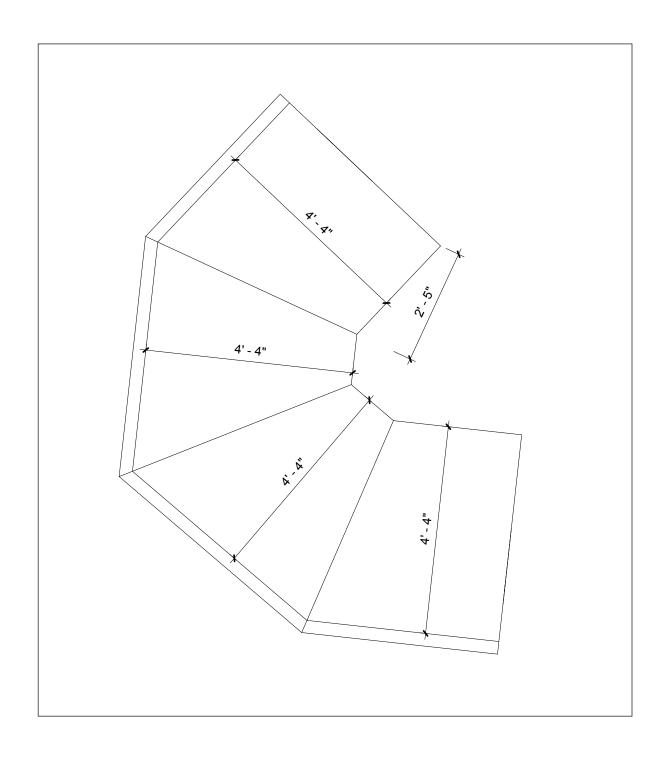


DETAIL PLAN


SCALE 1/2" = 1'-0"

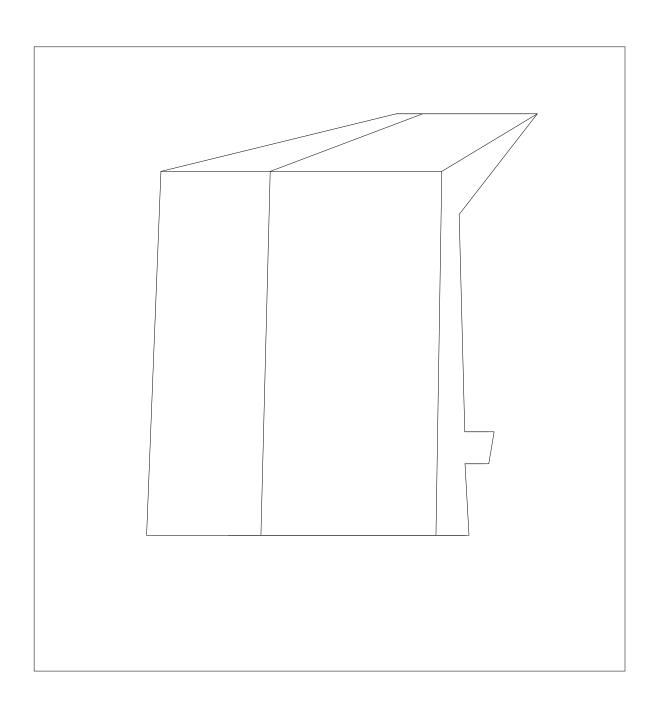

DETAIL SECTION


SCALE 1/2" = 1'-0"

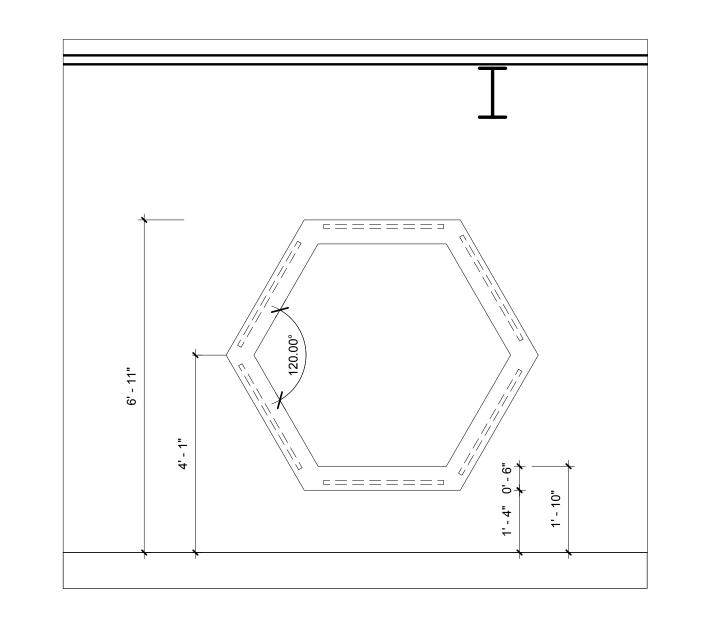

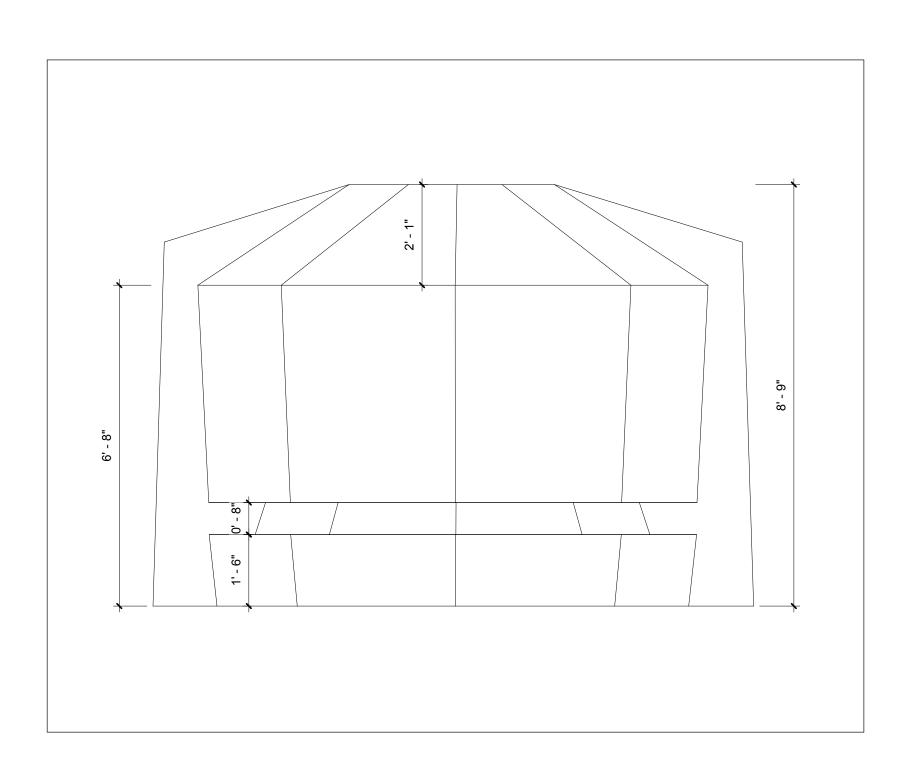


DETAIL ELEVATION

SCALE 1/2" = 1'-0"

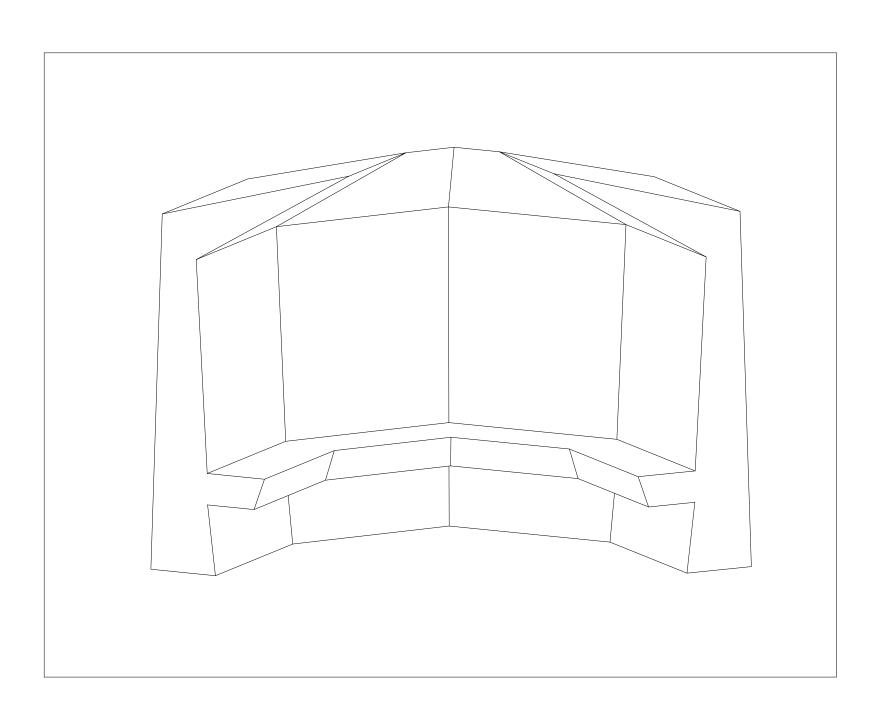

DETAIL ISOMETRIC

SCALE 1/2" = 1'-0"

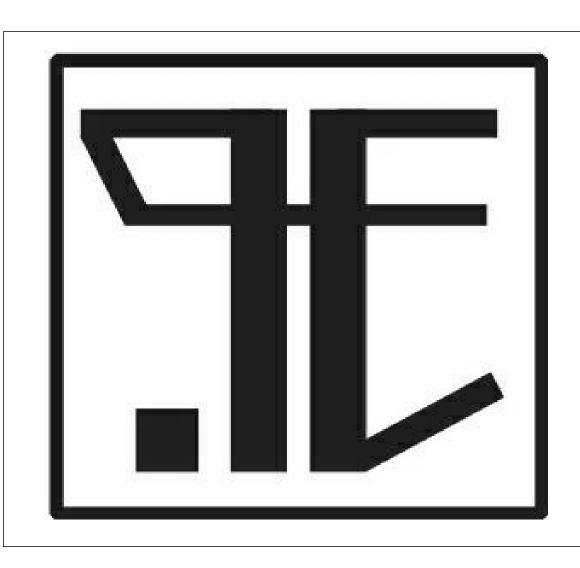

COJOLYA ASSOCIATION OF MAYA WOMEN WEAVERS

SECOND FLOOR ELEVATIONS AND DETAILS

Date MARCH 3RD, 2013


Drawn By ENYA YUN HUANG

Checked By ESMA DENGIZ

I 102

cale

2/23/2018 12:21:23 AM

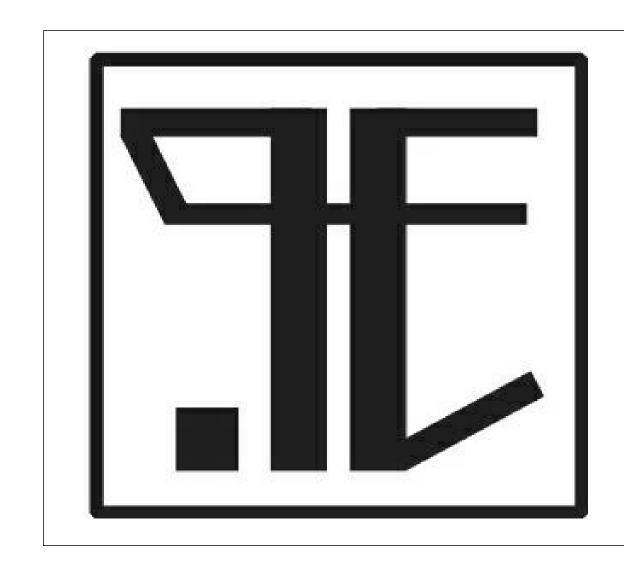

SECOND FLOOR REFLECTED CEILING PLAN

Date


Drawn By

Checked By

MARCH 3RD, 2013 ENYA YUN HUANG ESMA DENGIZ

I 103

Scale

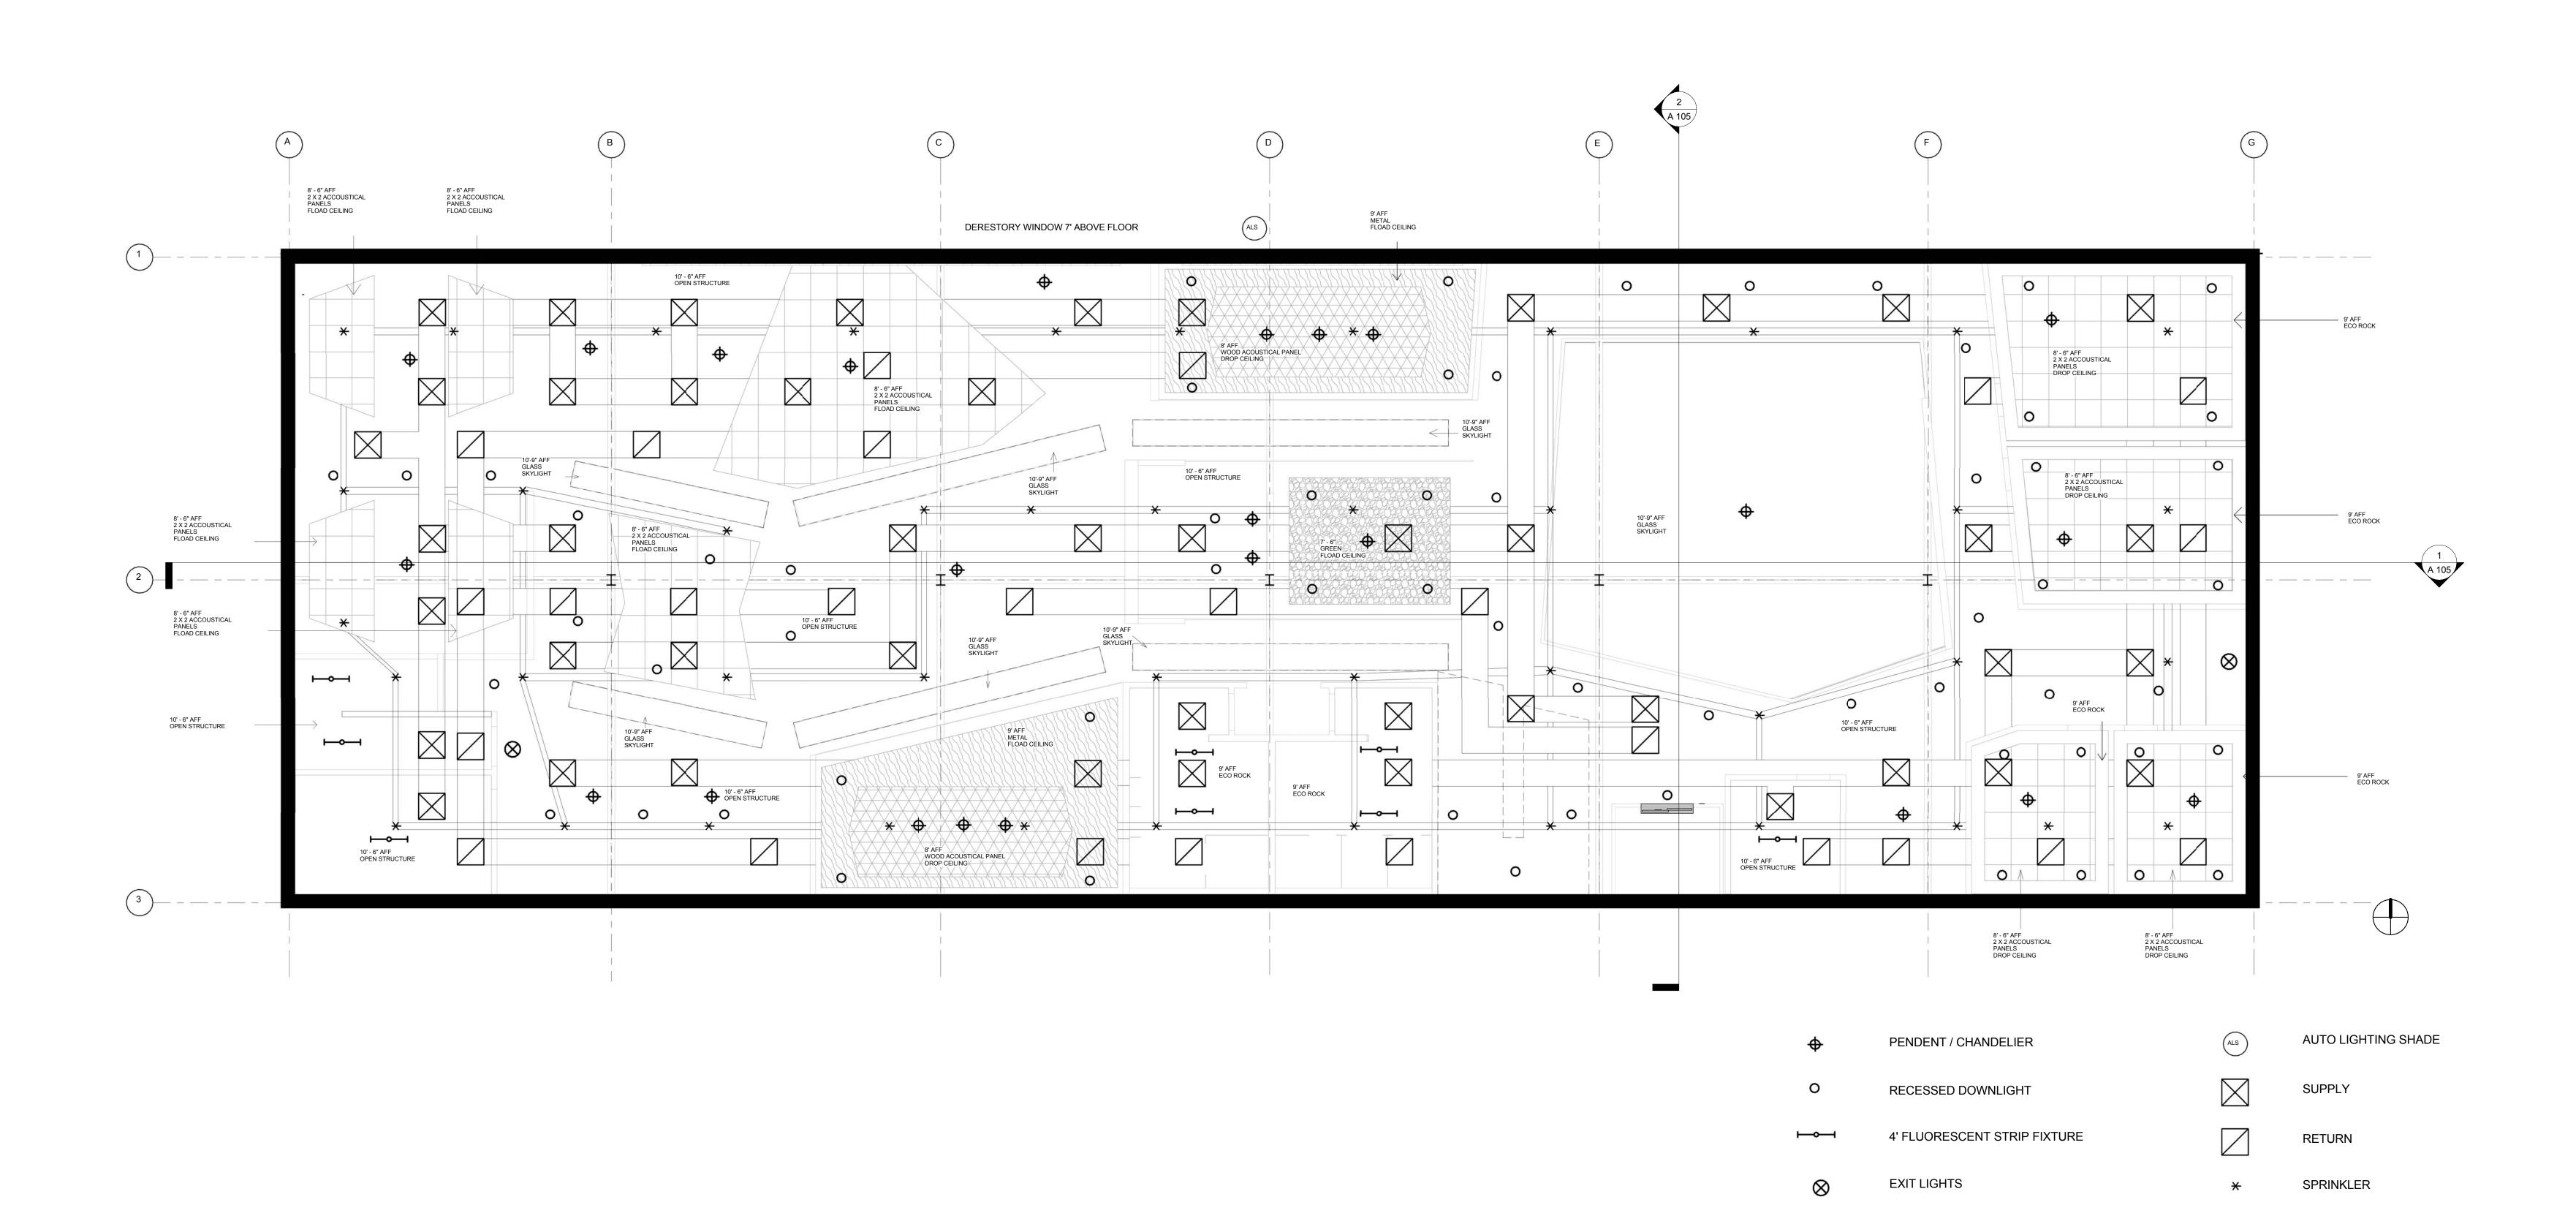

SECOND FLOOR REFLECTED CEILING PLAN